


REVISIONS			
Rev	by	Date	Comment
*			

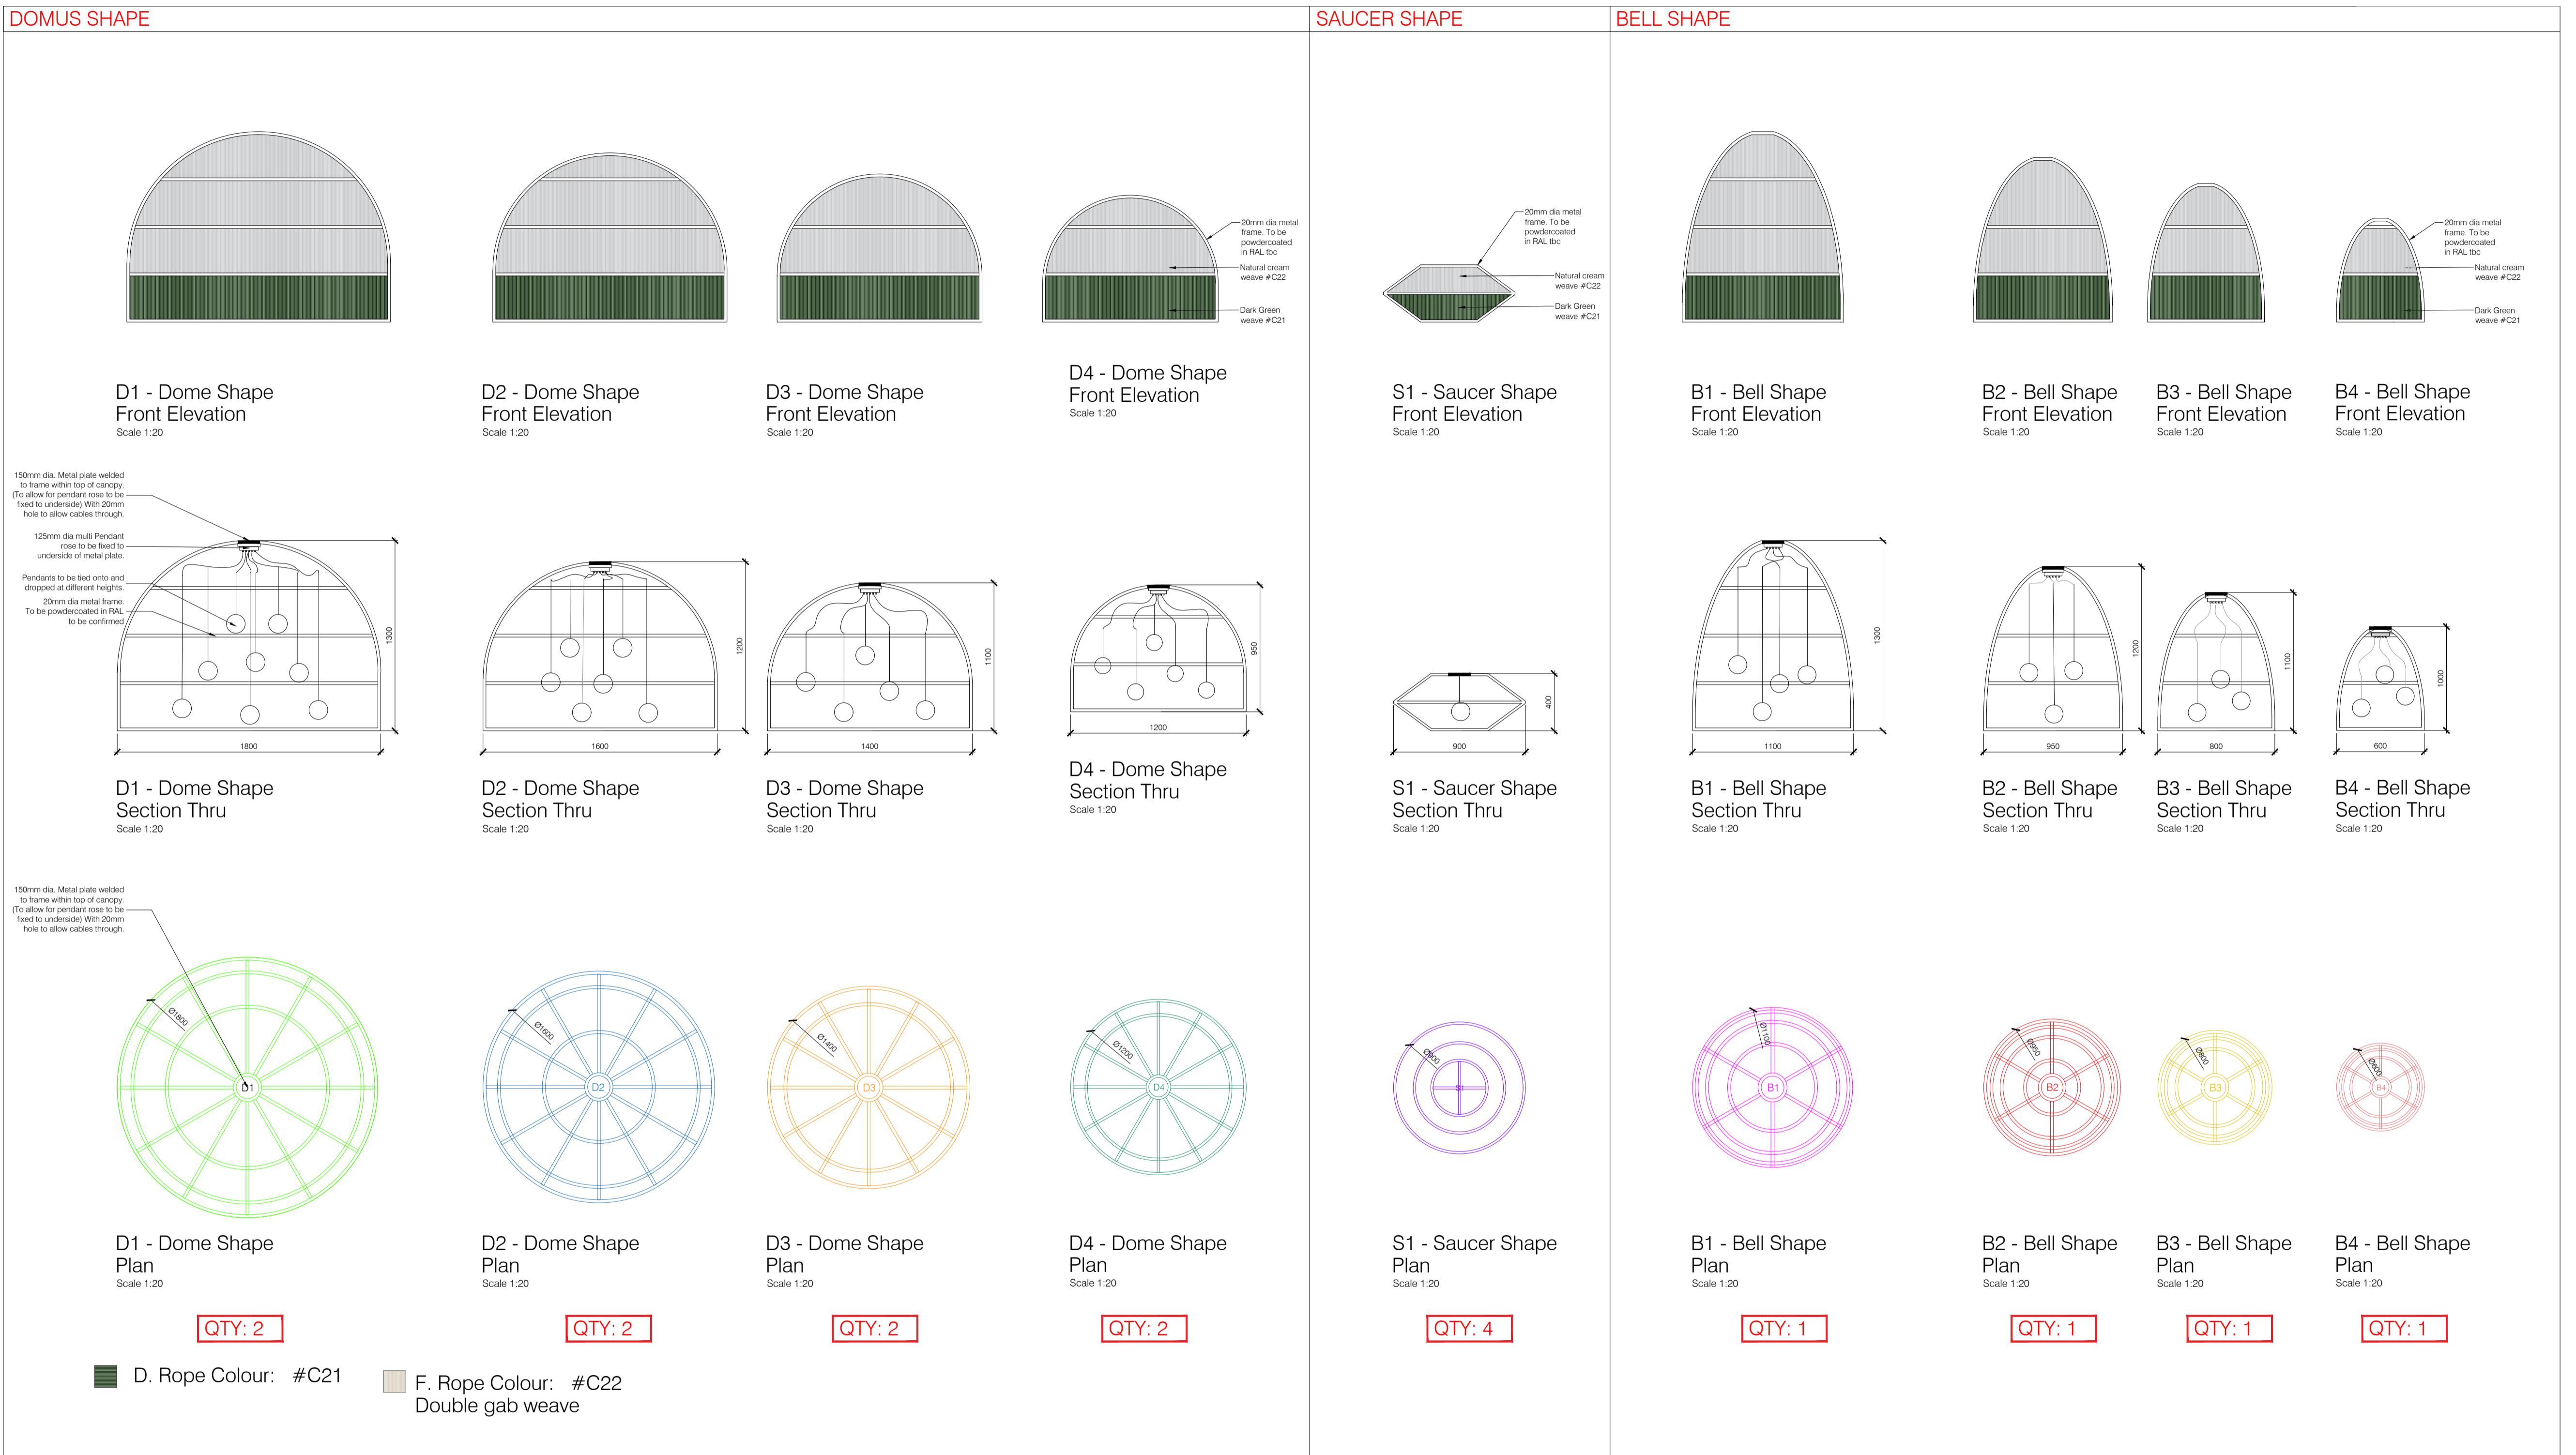

CLIENT
Nando's
PROJECT

Clink Street

TITLE	
Decorative Lighting Layout Ashanti Lights	
DRAWN	CHECKED
AL	DATE
SCALE @ A1	
As stated	June 2023
DRAWING NO.	
5274/10.2	FOR TENDER